

SOUTHWESTERN COLLEGE

PROJECT NAME

Southwestern College Baseball and Softball **Facilities Remodel** 900 Otay Lakes Road Chula Vista, CA 91910

DESIGN CONSULTANT



San Diego, CA 92108 T 619.294.7515 F 619.294.7592 www.sillmanwright.com

**DESIGN CONSULTANT** 



F 858.385.0400

REGISTRATION STAMPS



MARK DATE DESCRIPTION DSA PROJECT NO. 04-119760 DESIGNER PROJ. NO.

ADDENDUM A


20033 CRC SV


SHEET TITLE

DEMOLITION PLAN

SHEET NUMBER

C-301 A

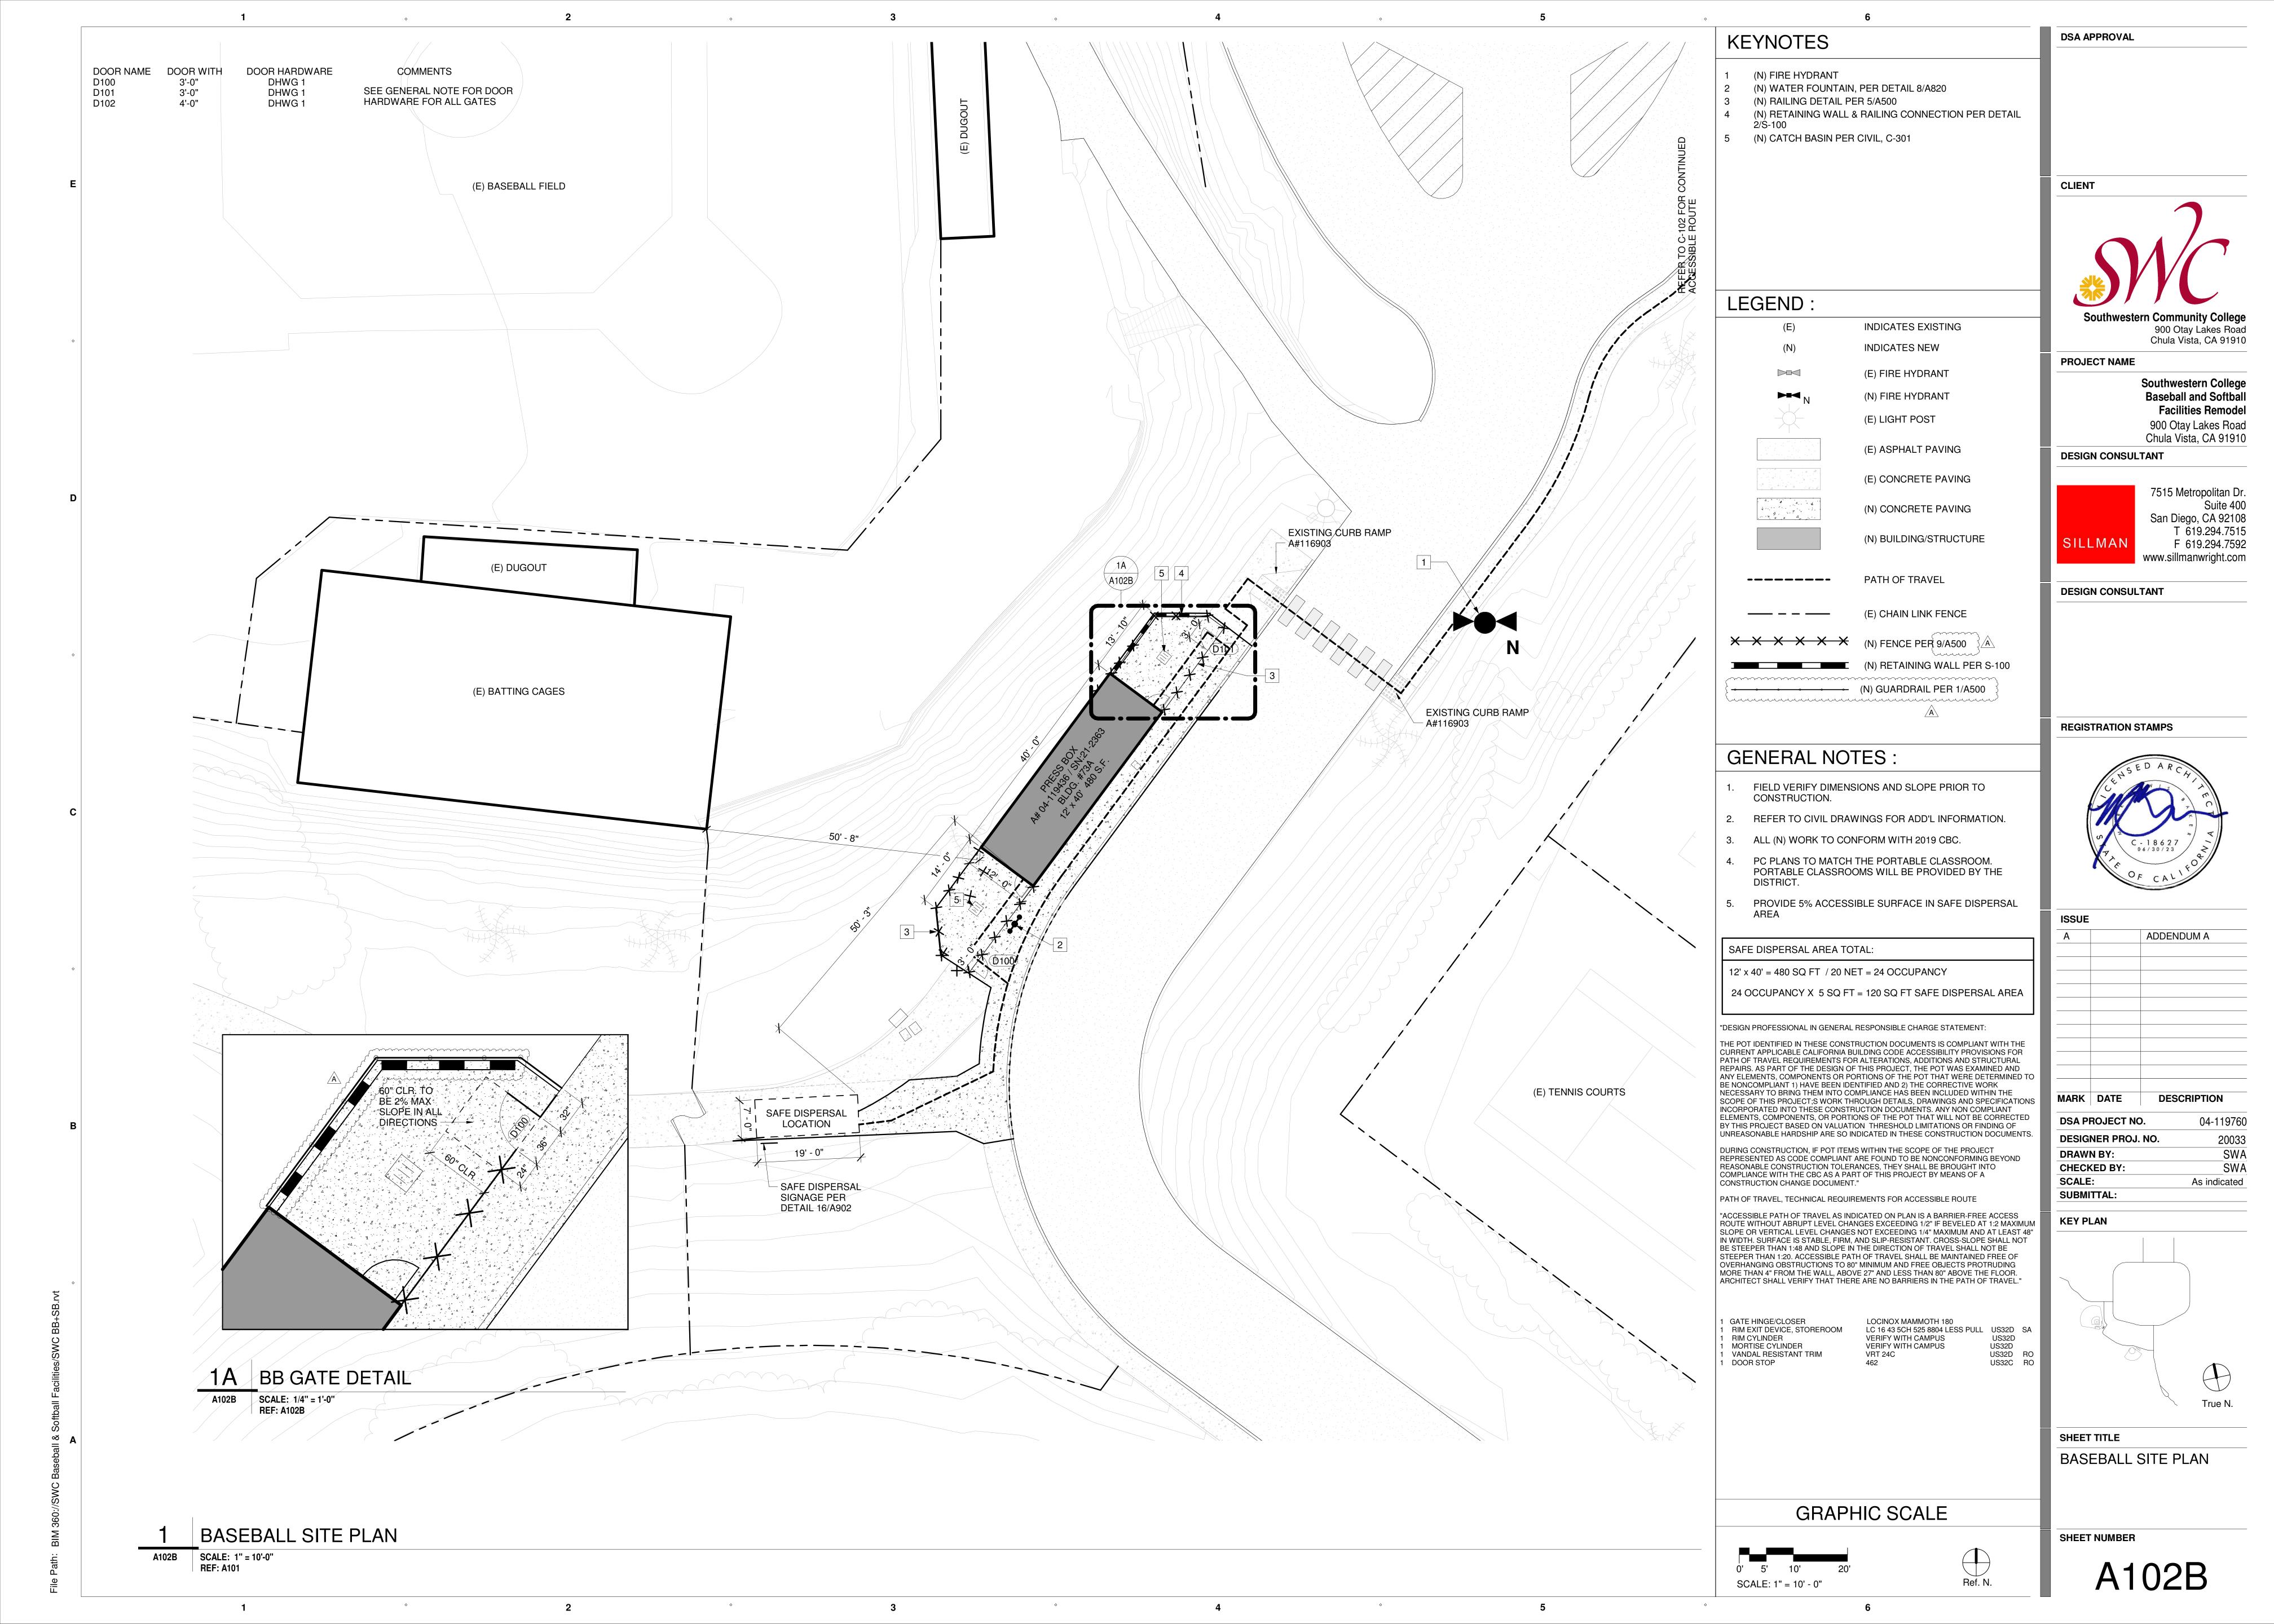


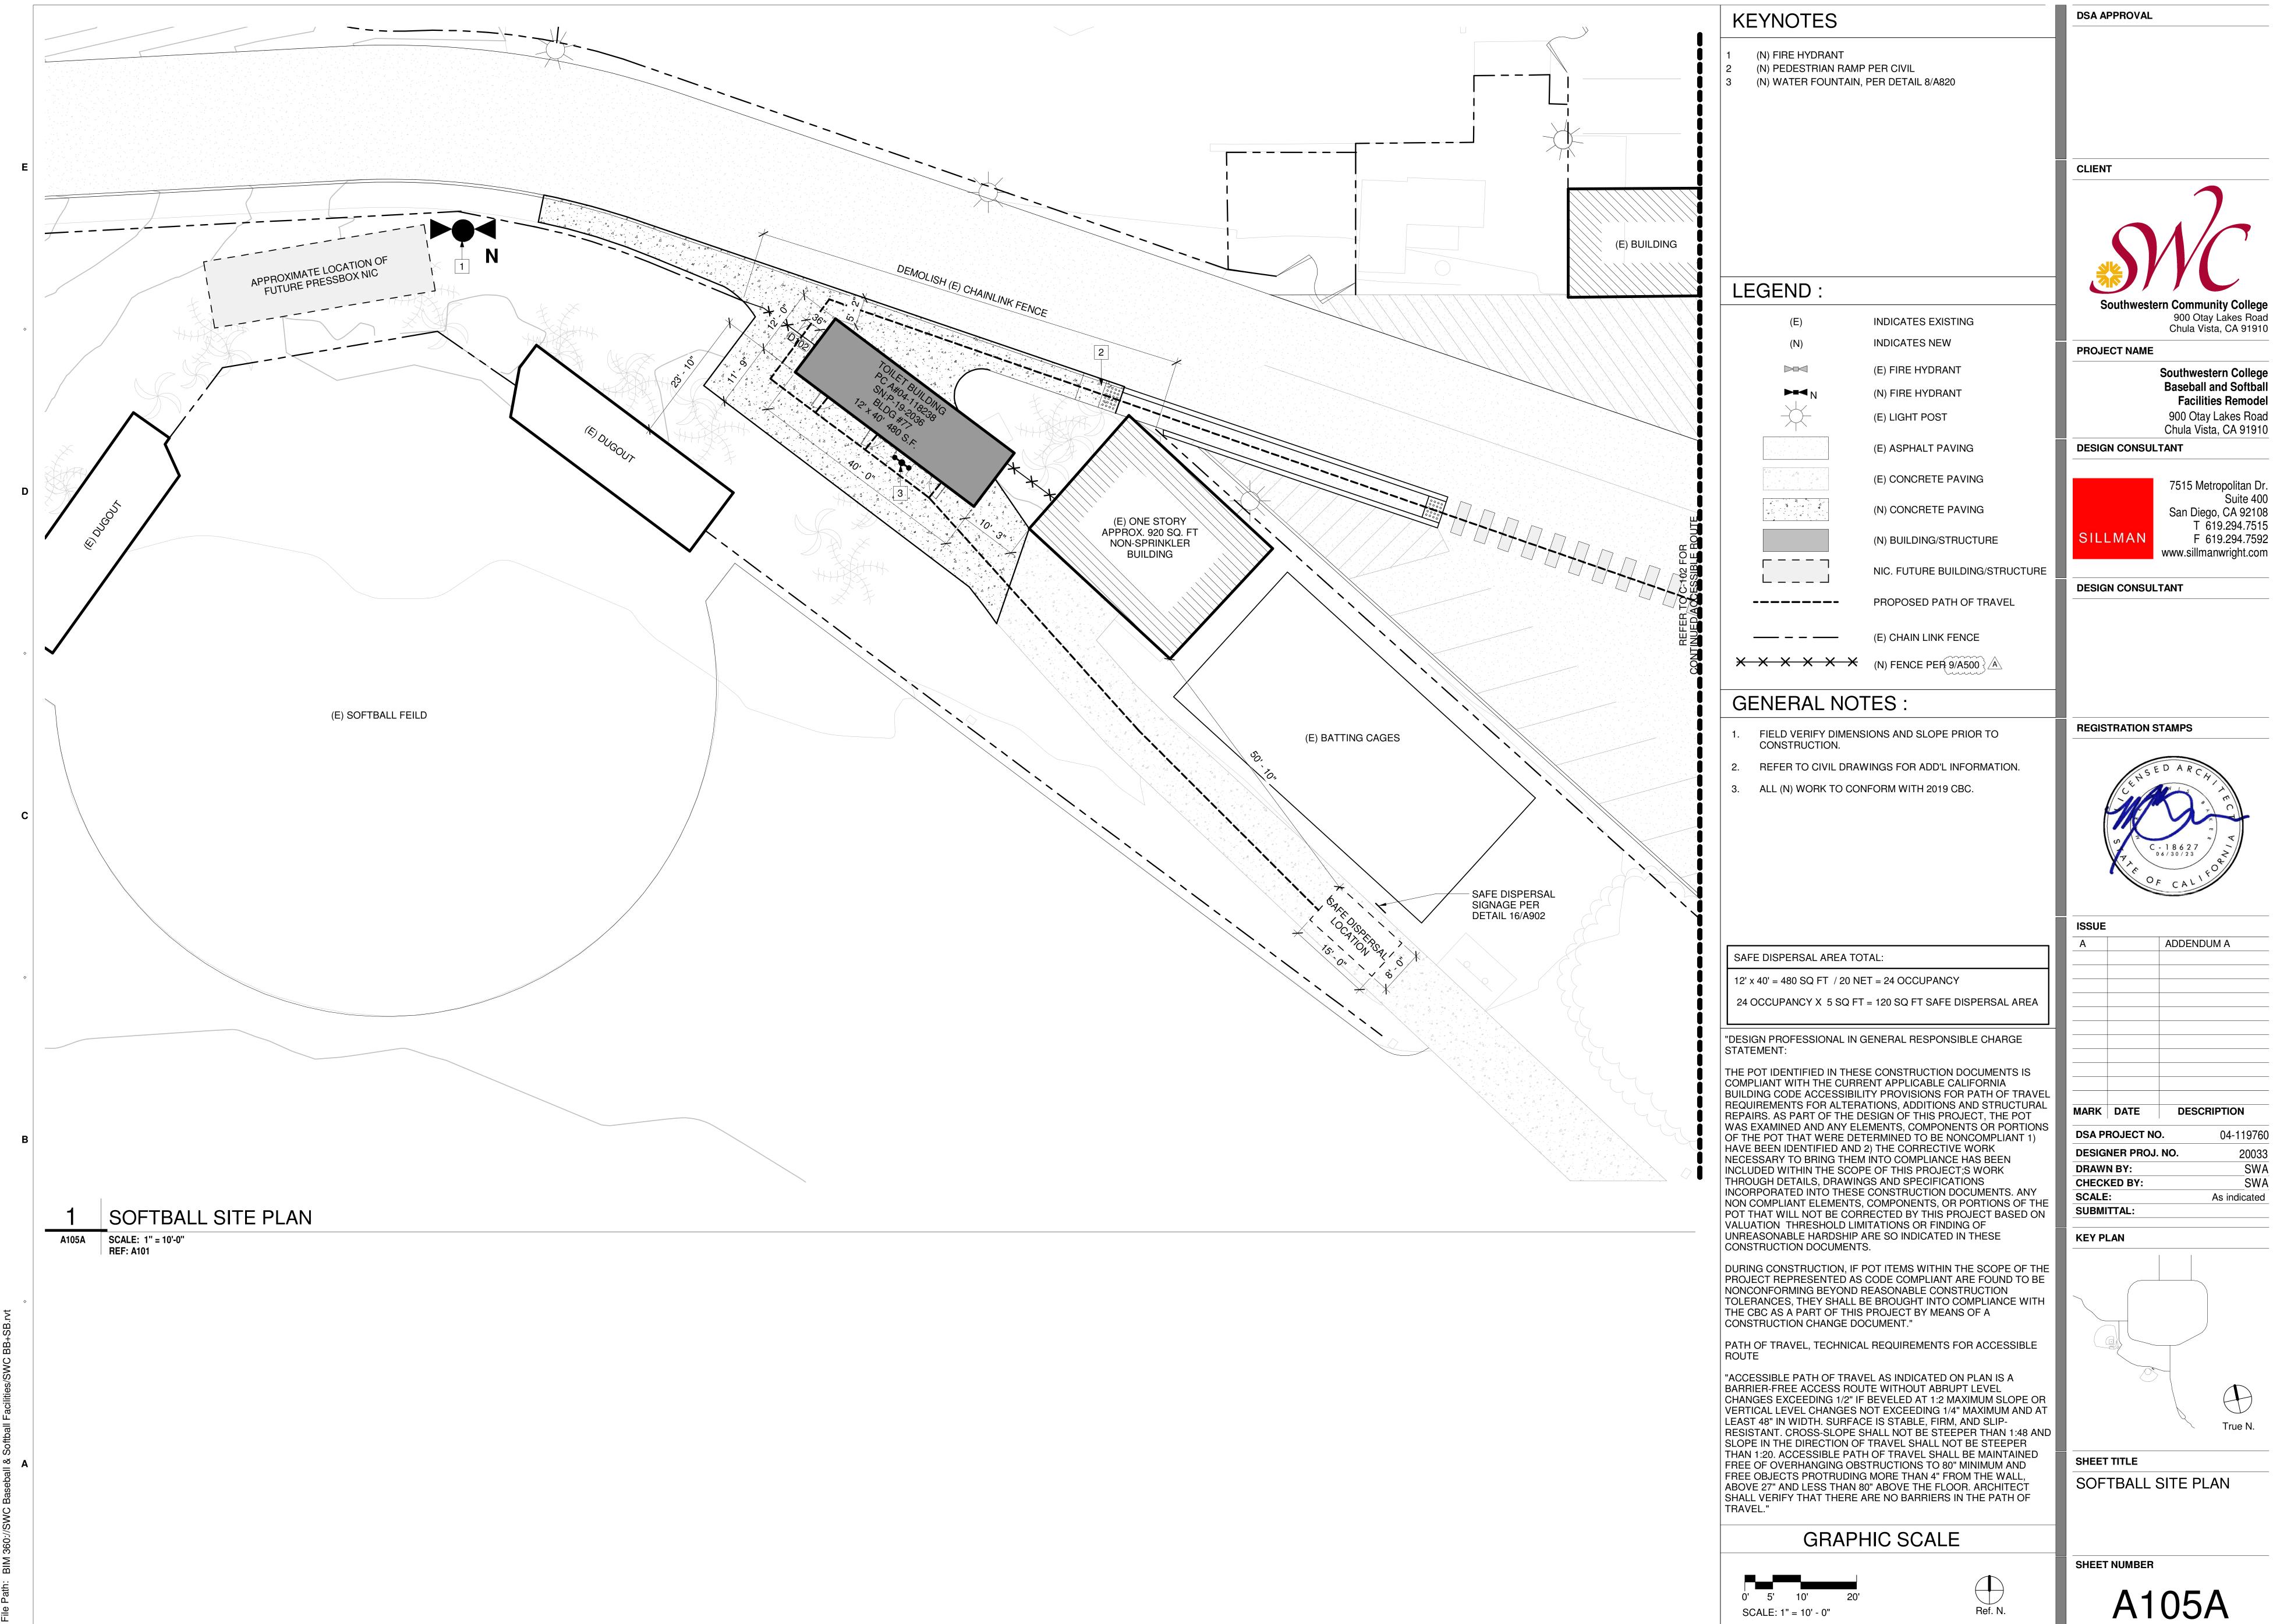


2

3

Baseball and Softball **Facilities Remodel** 

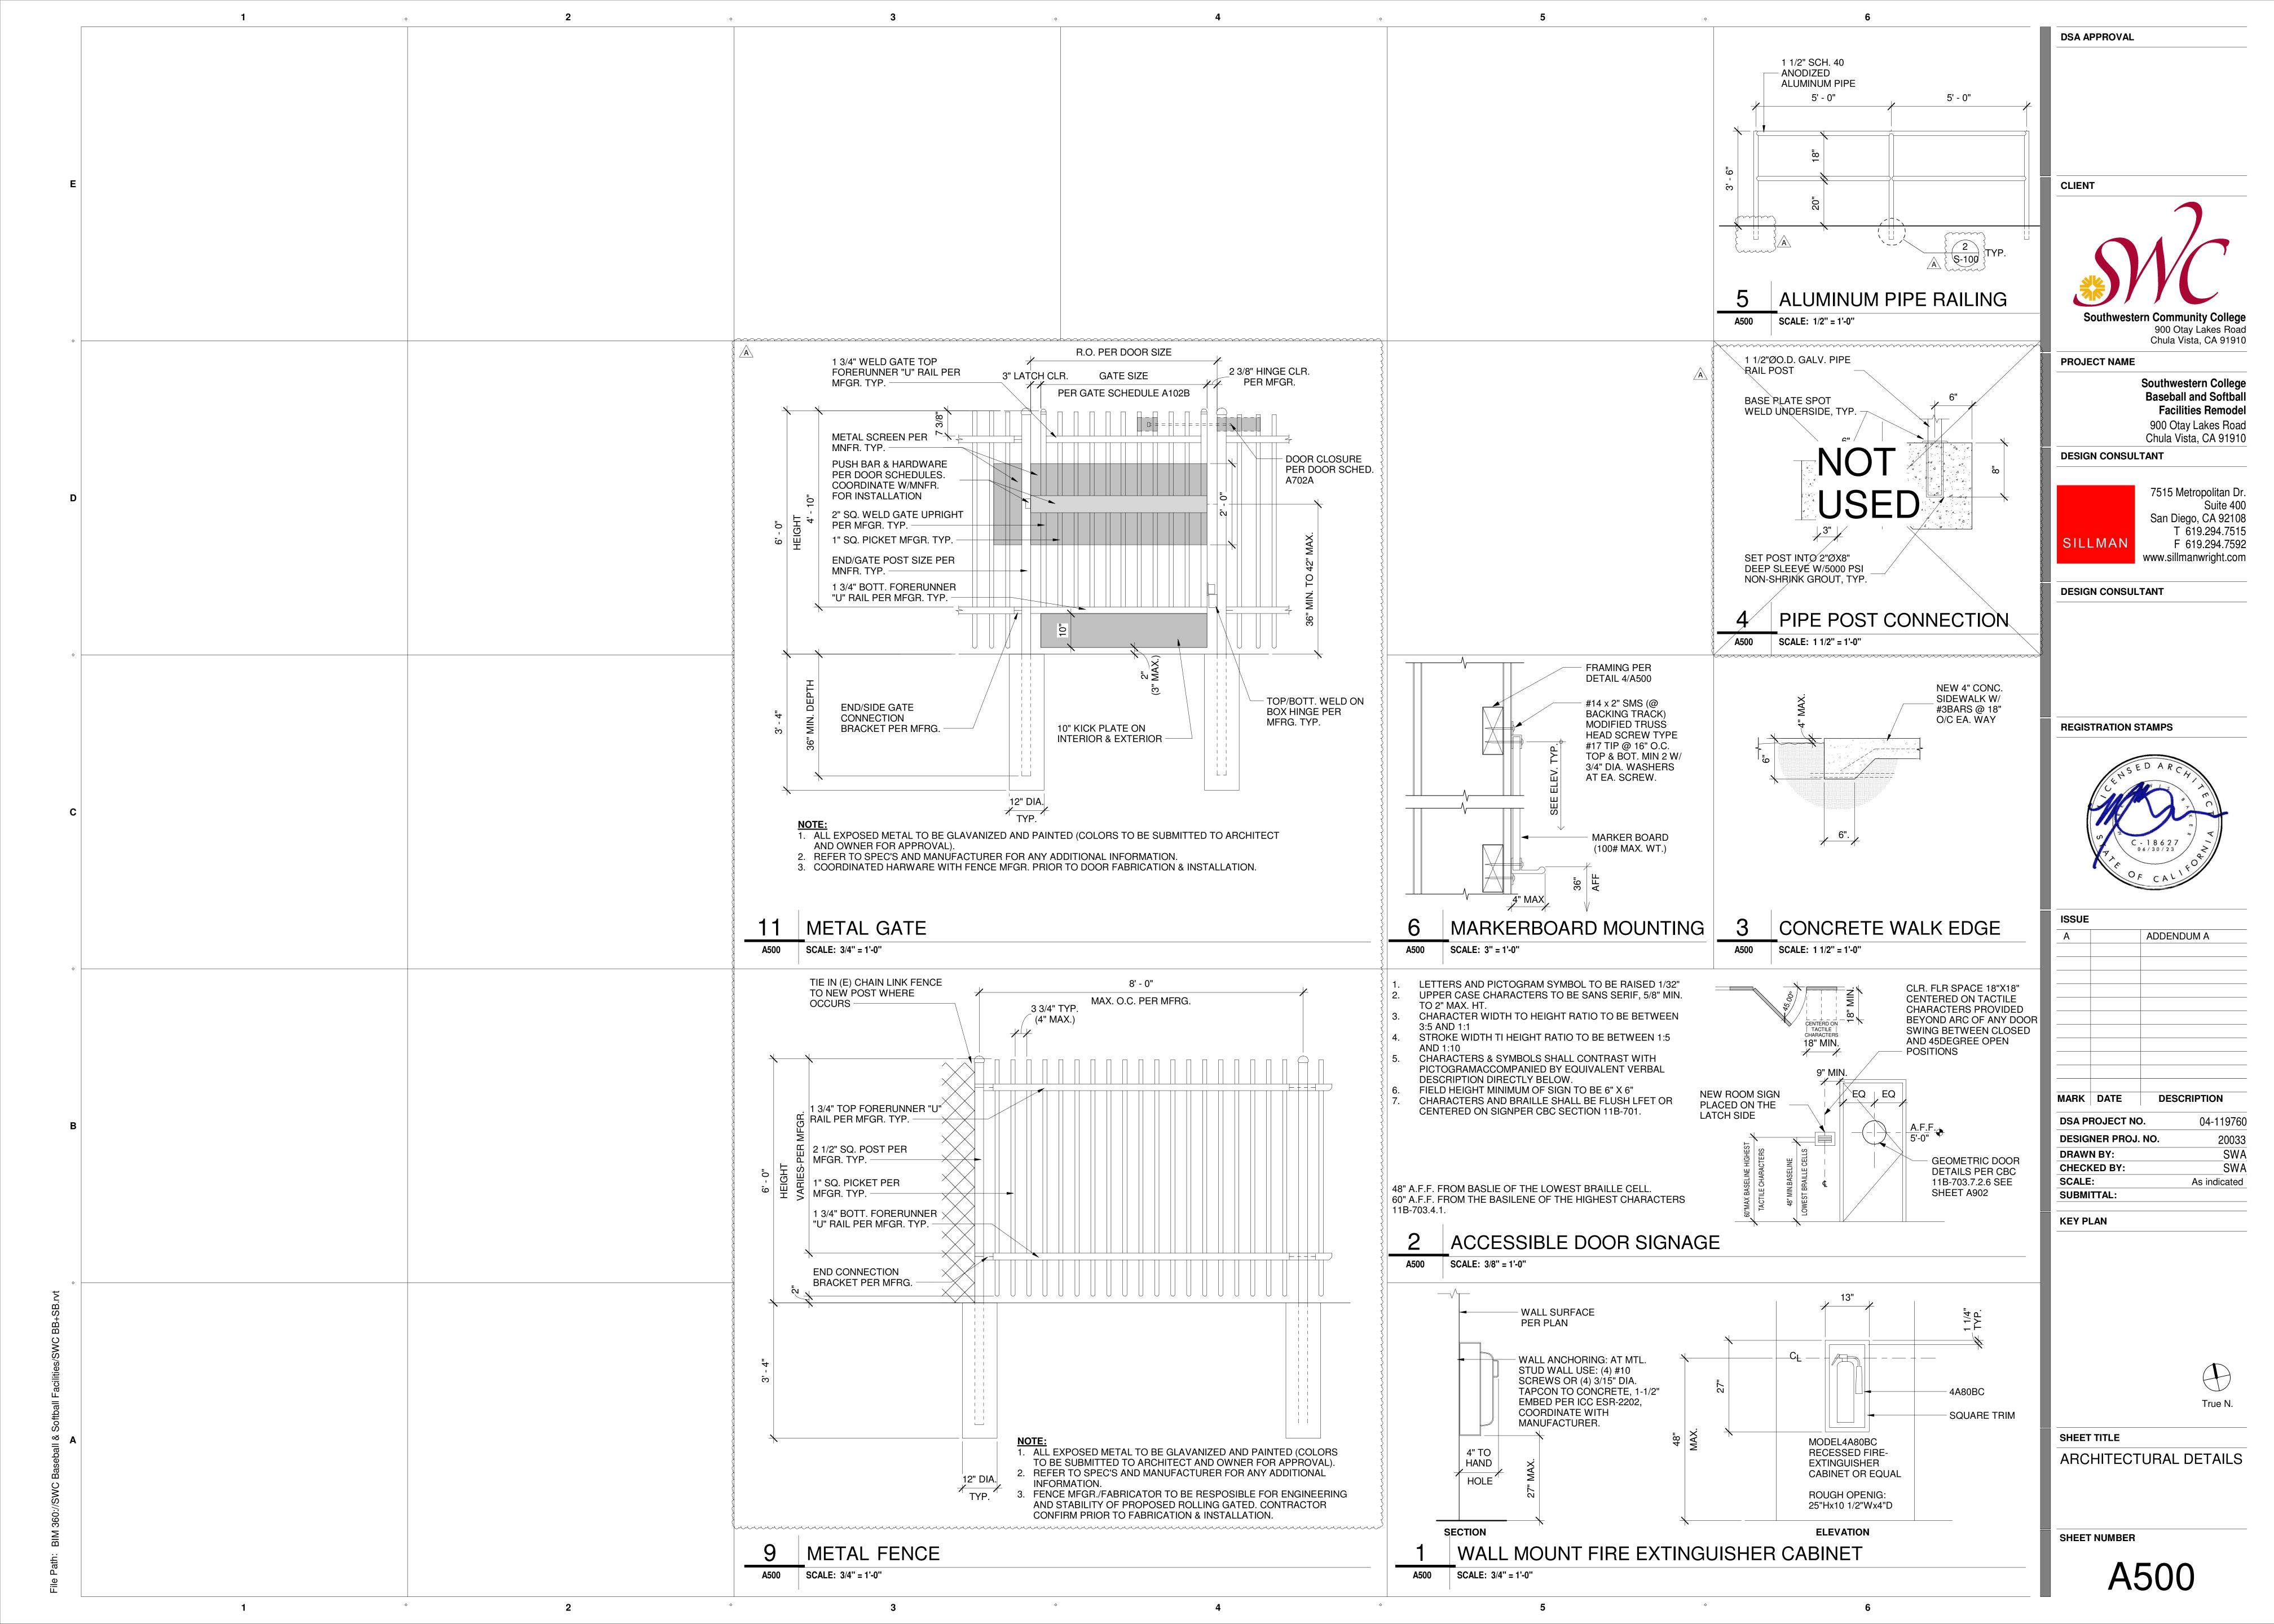

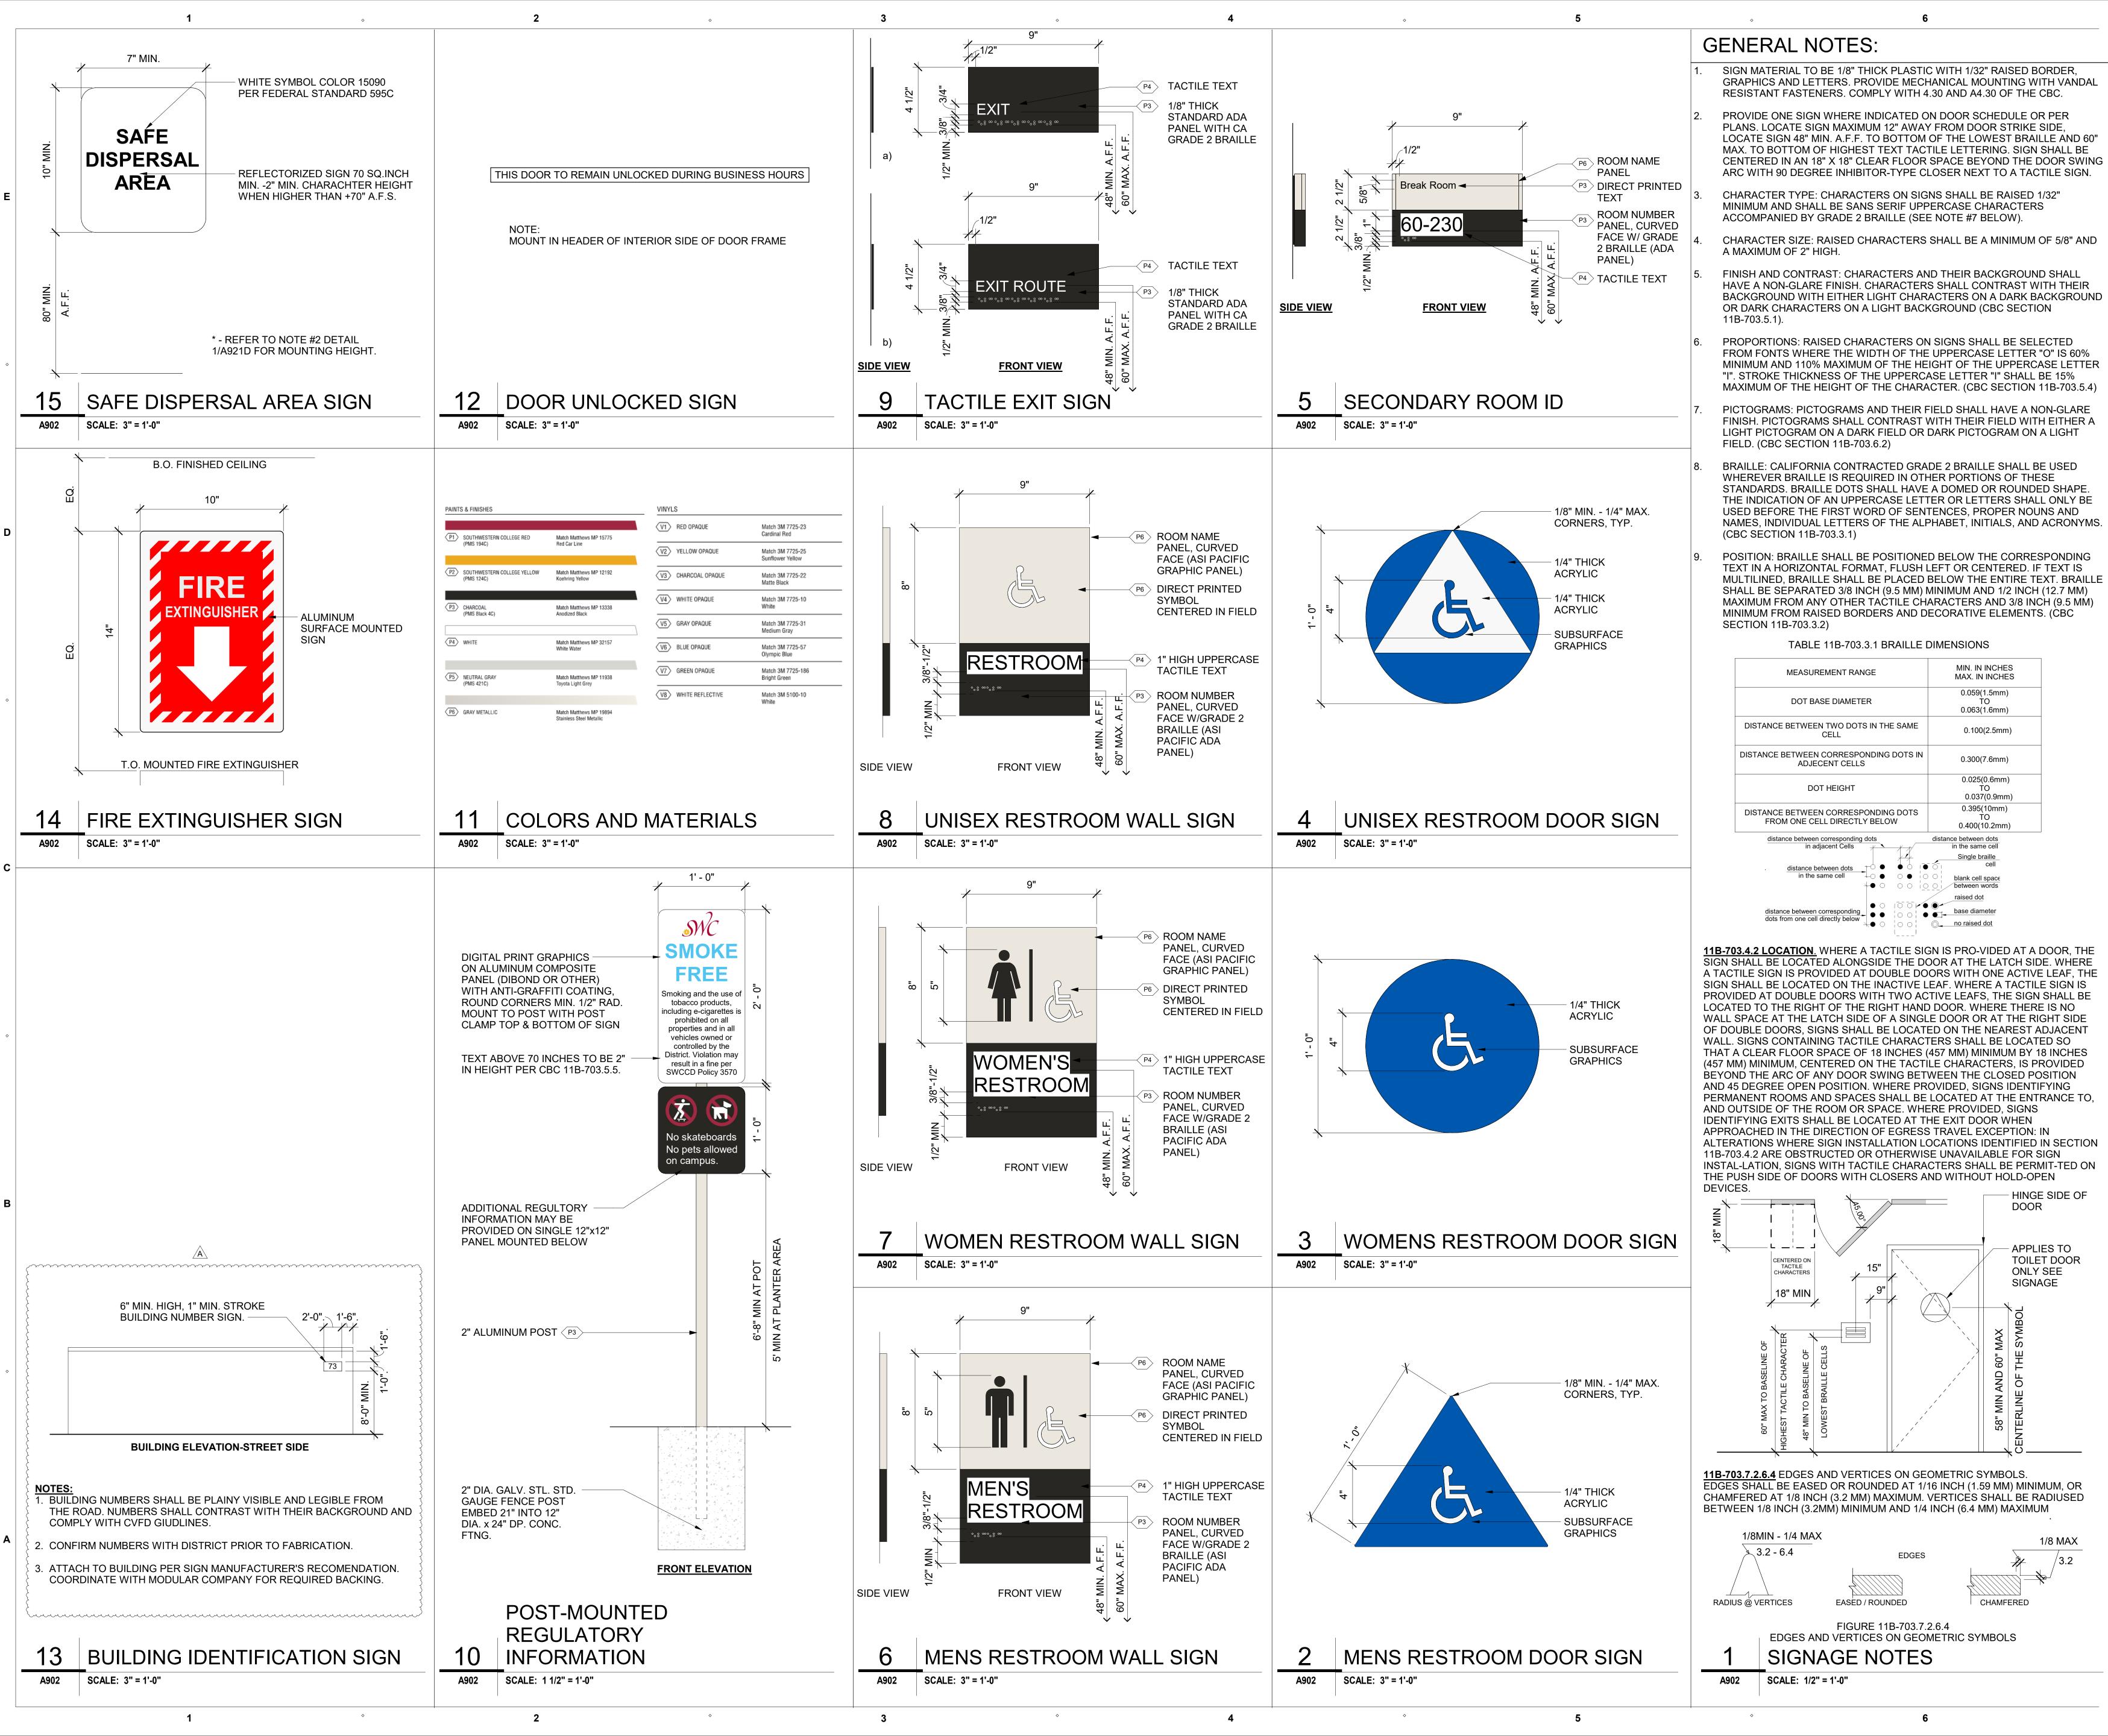

CLIENT

Southwestern Community College
900 Otay Lakes Road

900 Otay Lakes Road Chula Vista, CA 91910

PROJECT NAME
Southy

Southwestern College Baseball and Softball Facilities Remodel 900 Otay Lakes Road

Chula Vista, CA 91910

DESIGN CONSULTANT


SILLMAN 75

7515 Metropolitan Dr. Suite 400 San Diego, CA 92108 T 619.294.7515 F 619.294.7592 www.sillmanwright.com

DESIGN CONSULTANT

REGISTRATION STAMPS



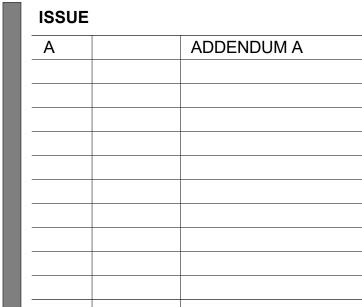

MARKDATEDESCRIPTIONDSA PROJECT NO.04-119760DESIGNER PROJ. NO.20033DRAWN BY:SWA

SCALE: SUBMITTAL:

KEY PLAN

**CHECKED BY:** 

True N.

SWA

As indicated


SHEET TITLE

SIGNAGE DETAILS

SHEET NUMBER

A902

## SOUTHWESTERN COLLEGE BASEBALL & SOFTBALL FACILITIES REMODEL 900 OTAY LAKES ROAD, CHULA VISTA, CA 91910

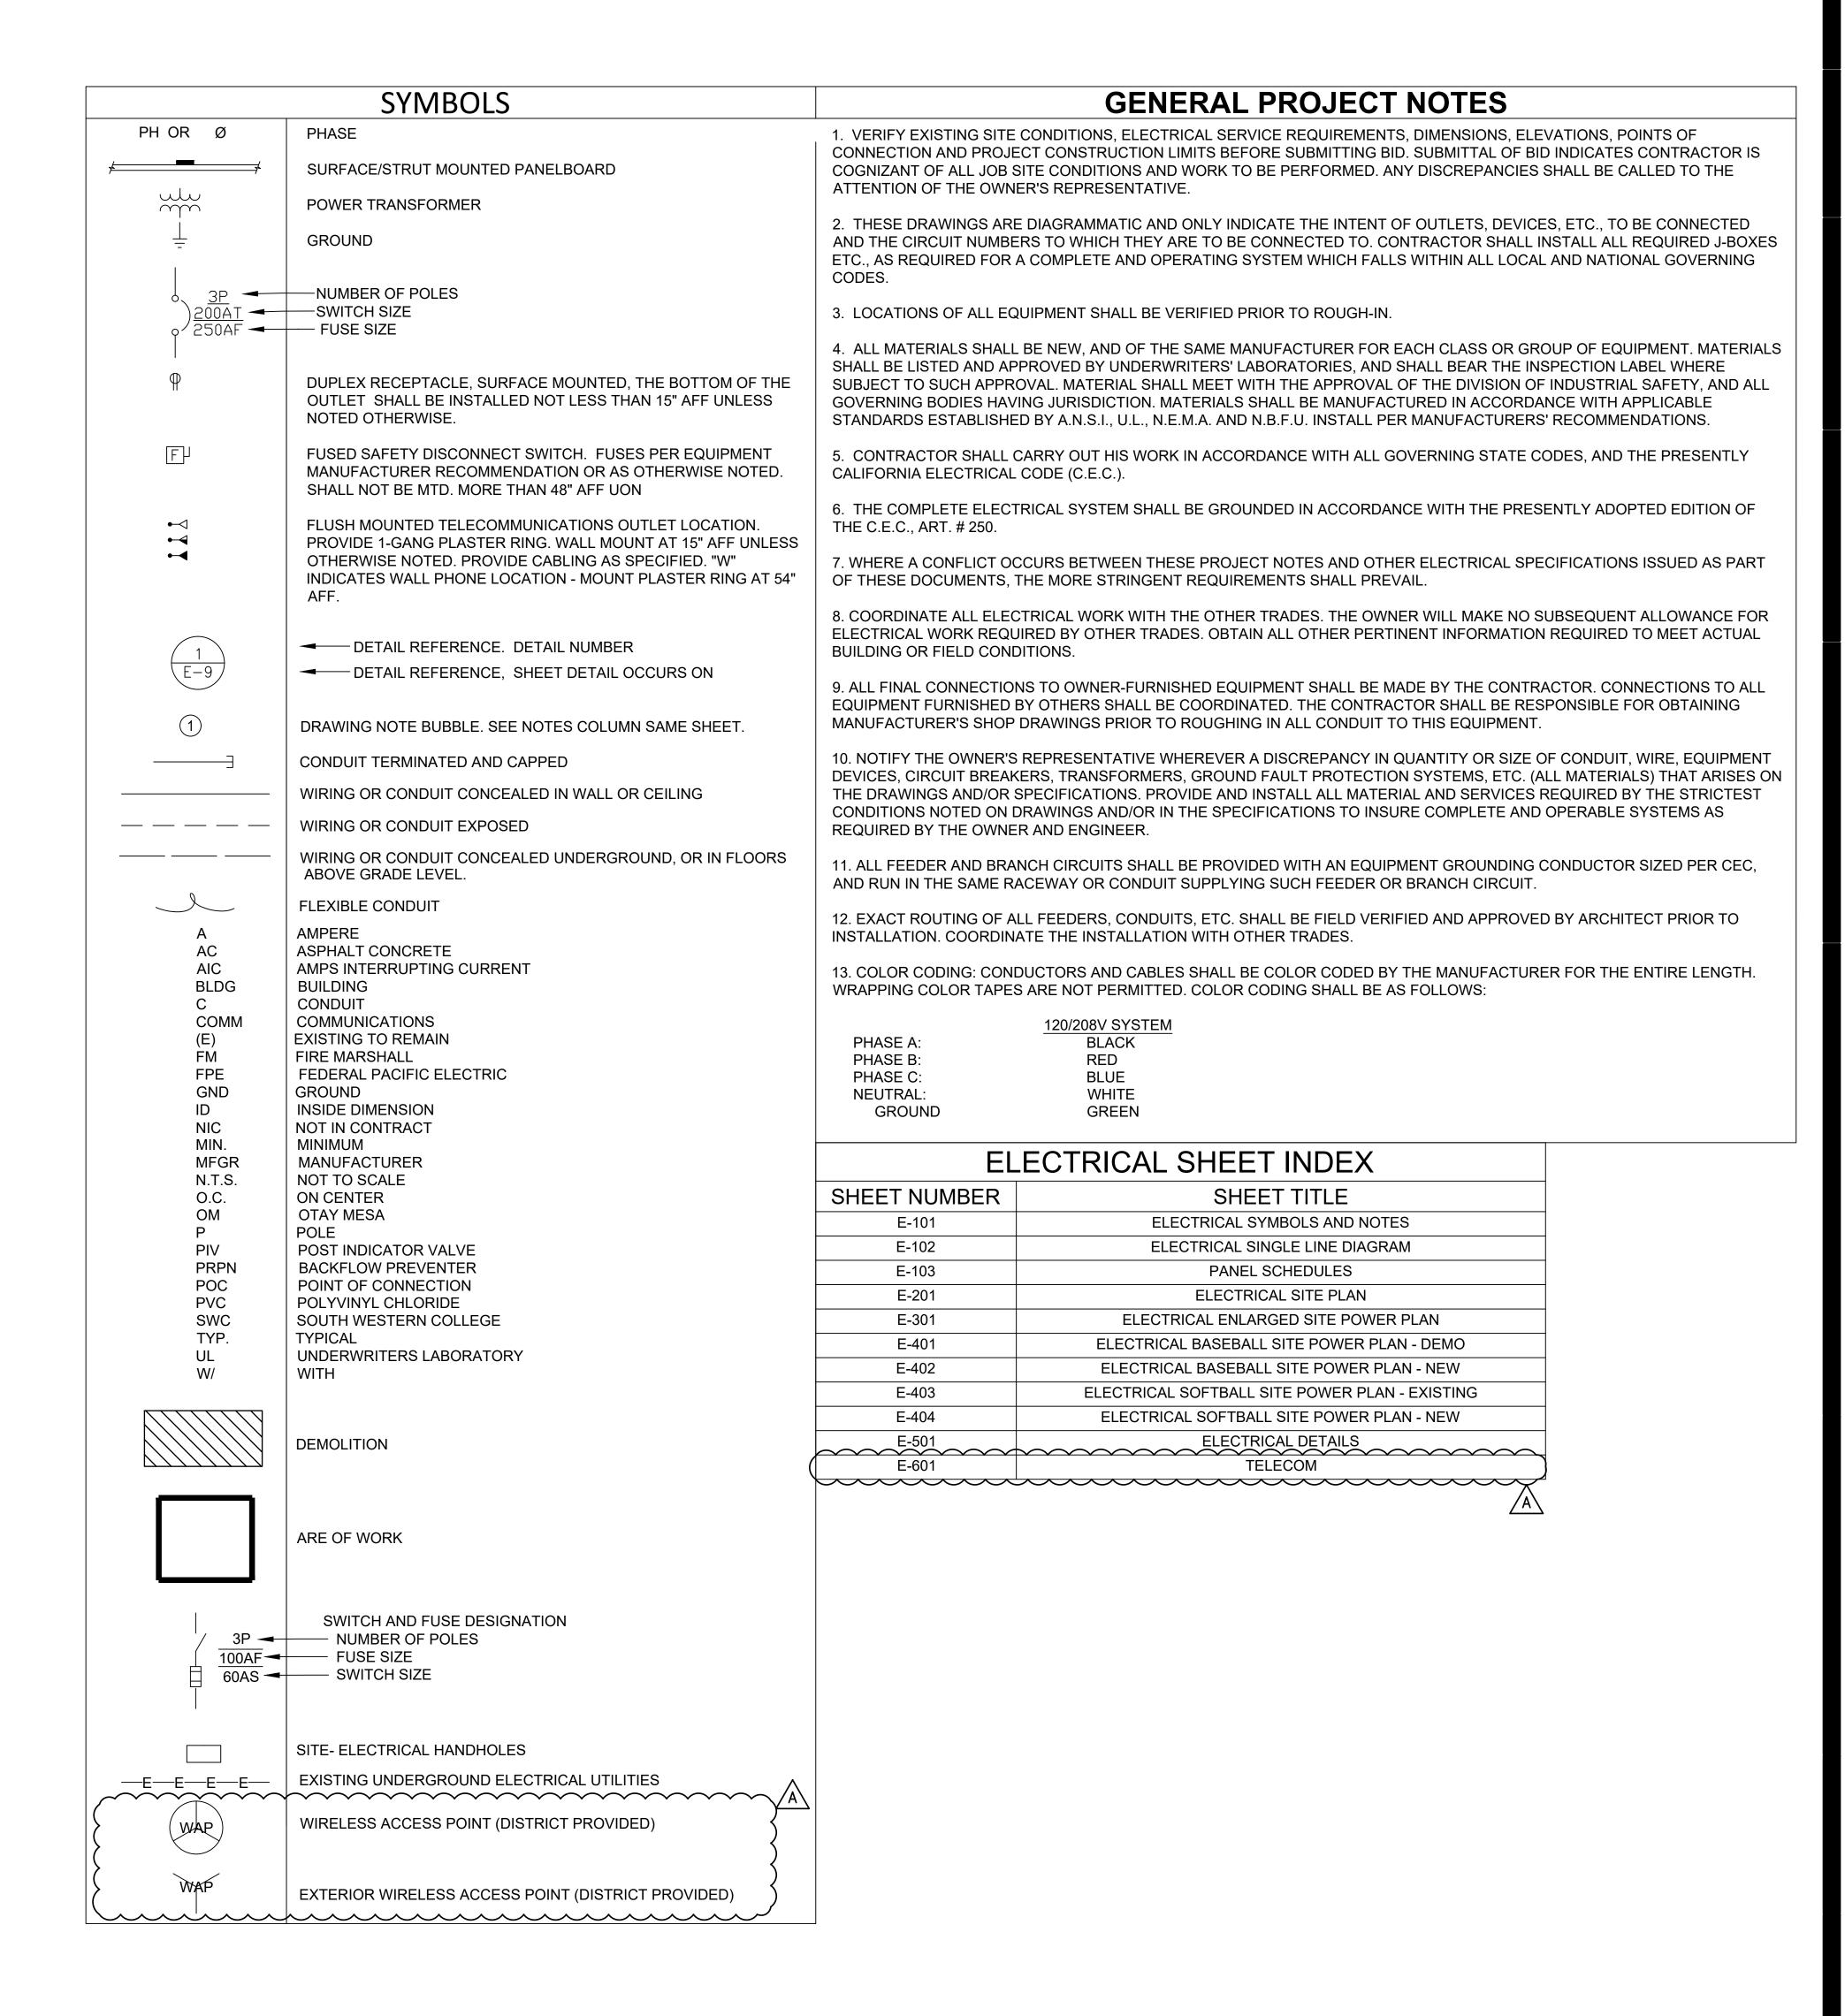

DSA APPROVAL

CLIE

Southwestern Community College

Chula Vista, CA 91910

Southwestern College
Operations & Warehouse Relocation
Increment 3 (Building A, B, & C)

DESIGN CONSULTANT




7515 Metropolitan Dr. Suite 400 San Diego, CA 92108 T 619.294.7515 F 619.294.7592 www.sillmanwright.com

Chula Vista, CA 91910

DESIGN CONSULTANT

REGISTRATION STAMPS

ISSUE

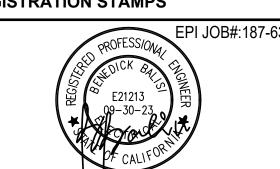

THE ENGINEERING PARTNERS, INC.

CONSULTING ENGINEERS

10150 MEANLEY DRIVE, SUITE 200

SAN DIEGO, CA 92131
(858) 824-1761 FAX (858) 824-1768

$A \setminus$	XX/XX/XX	DELTA A
MARK	DATE	DESCRIPTION
	-	
DSA P	ROJECT N	<b>O</b> . 04-118597
DESIG	NER PRO	. <b>NO</b> . 18048

DRAWN BY: SWA
CHECKED BY: SWA
SCALE:
SUBMITTAL:
KEY PLAN




SHEET TITLE

ELECTRICAL SYMBOLS AND NOTES

SHEET NUMBER

**□** 101

ile Dath.

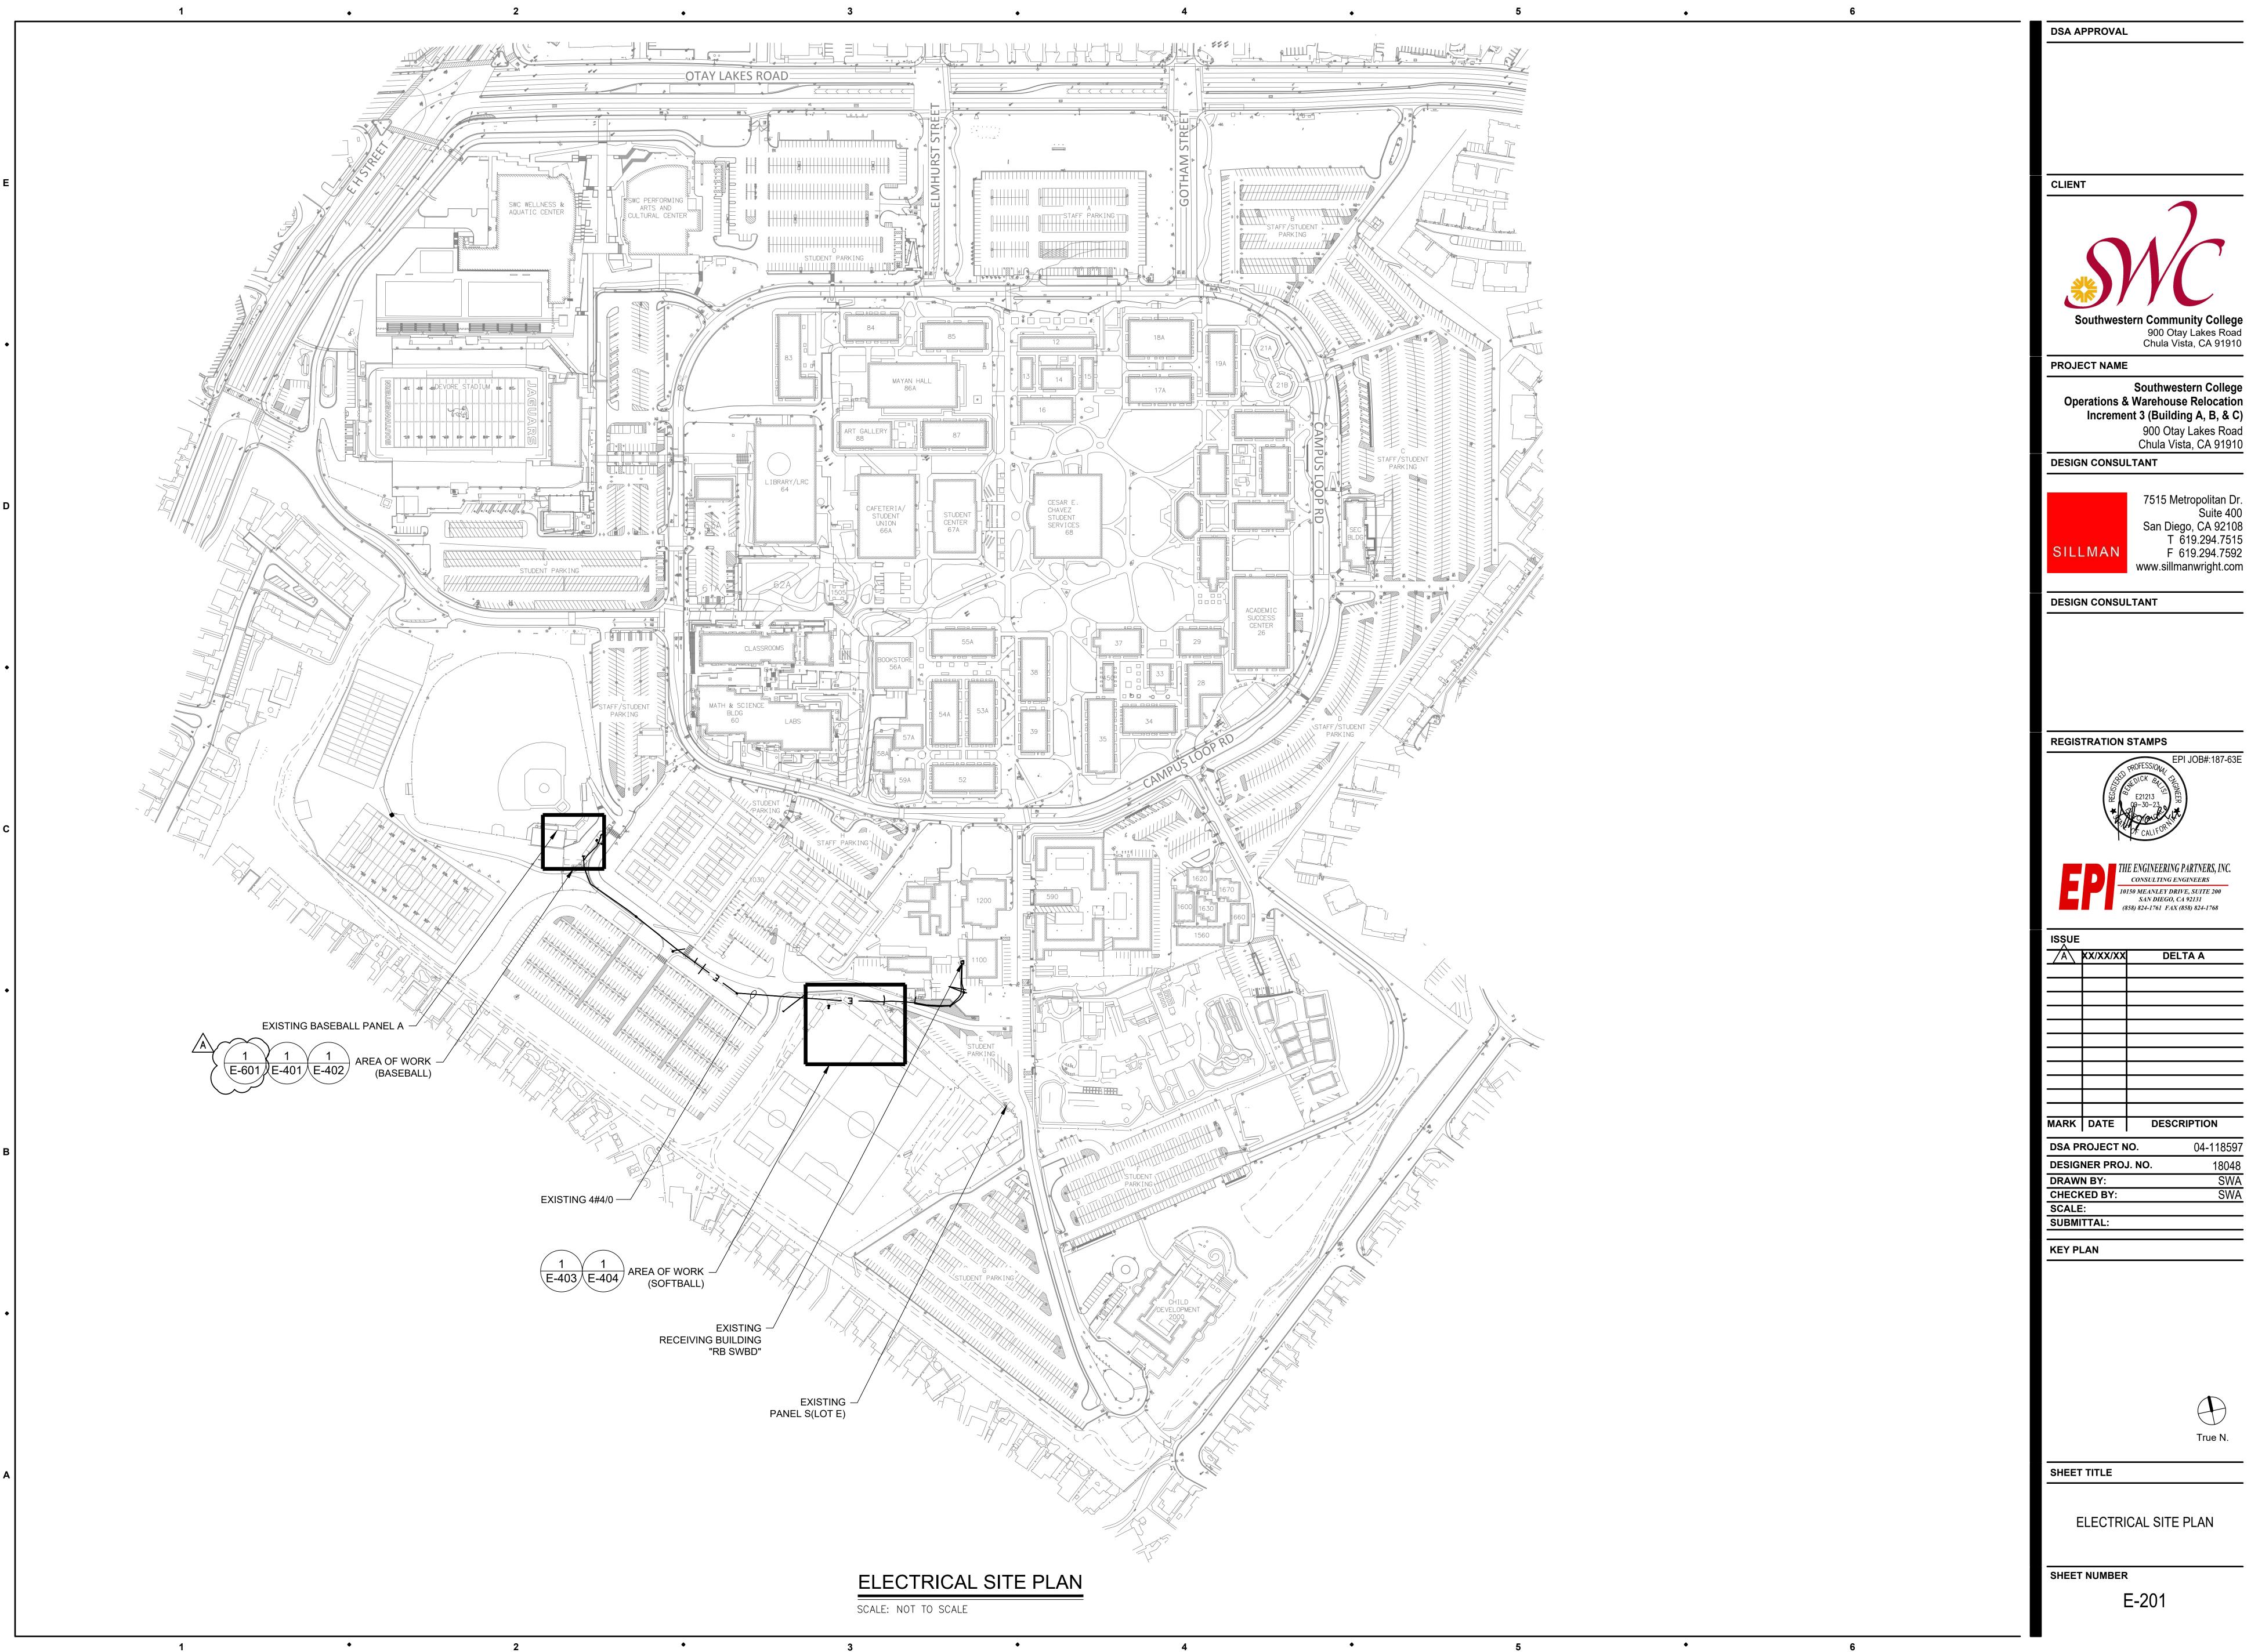

Southwestern College Operations & Warehouse Relocation Increment 3 (Building A, B, & C) 900 Otay Lakes Road Chula Vista, CA 91910



7515 Metropolitan Dr. Suite 400 San Diego, CA 92108 T 619.294.7515 F 619.294.7592 www.sillmanwright.com

**DESIGN CONSULTANT** 

REGISTRATION STAMPS



10150 MEANLEY DRIVE, SUITE 200 SAN DIEGO, CA 92131 (858) 824-1761 FAX (858) 824-1768


DELTA A

IARK	DATE	DESCRI	PTION
<b>DSA PROJECT NO.</b> 04-118597			
DESIGNER PROJ. NO. 18048			18048

SWA SWA

ELECTRICAL SITE PLAN

E-201

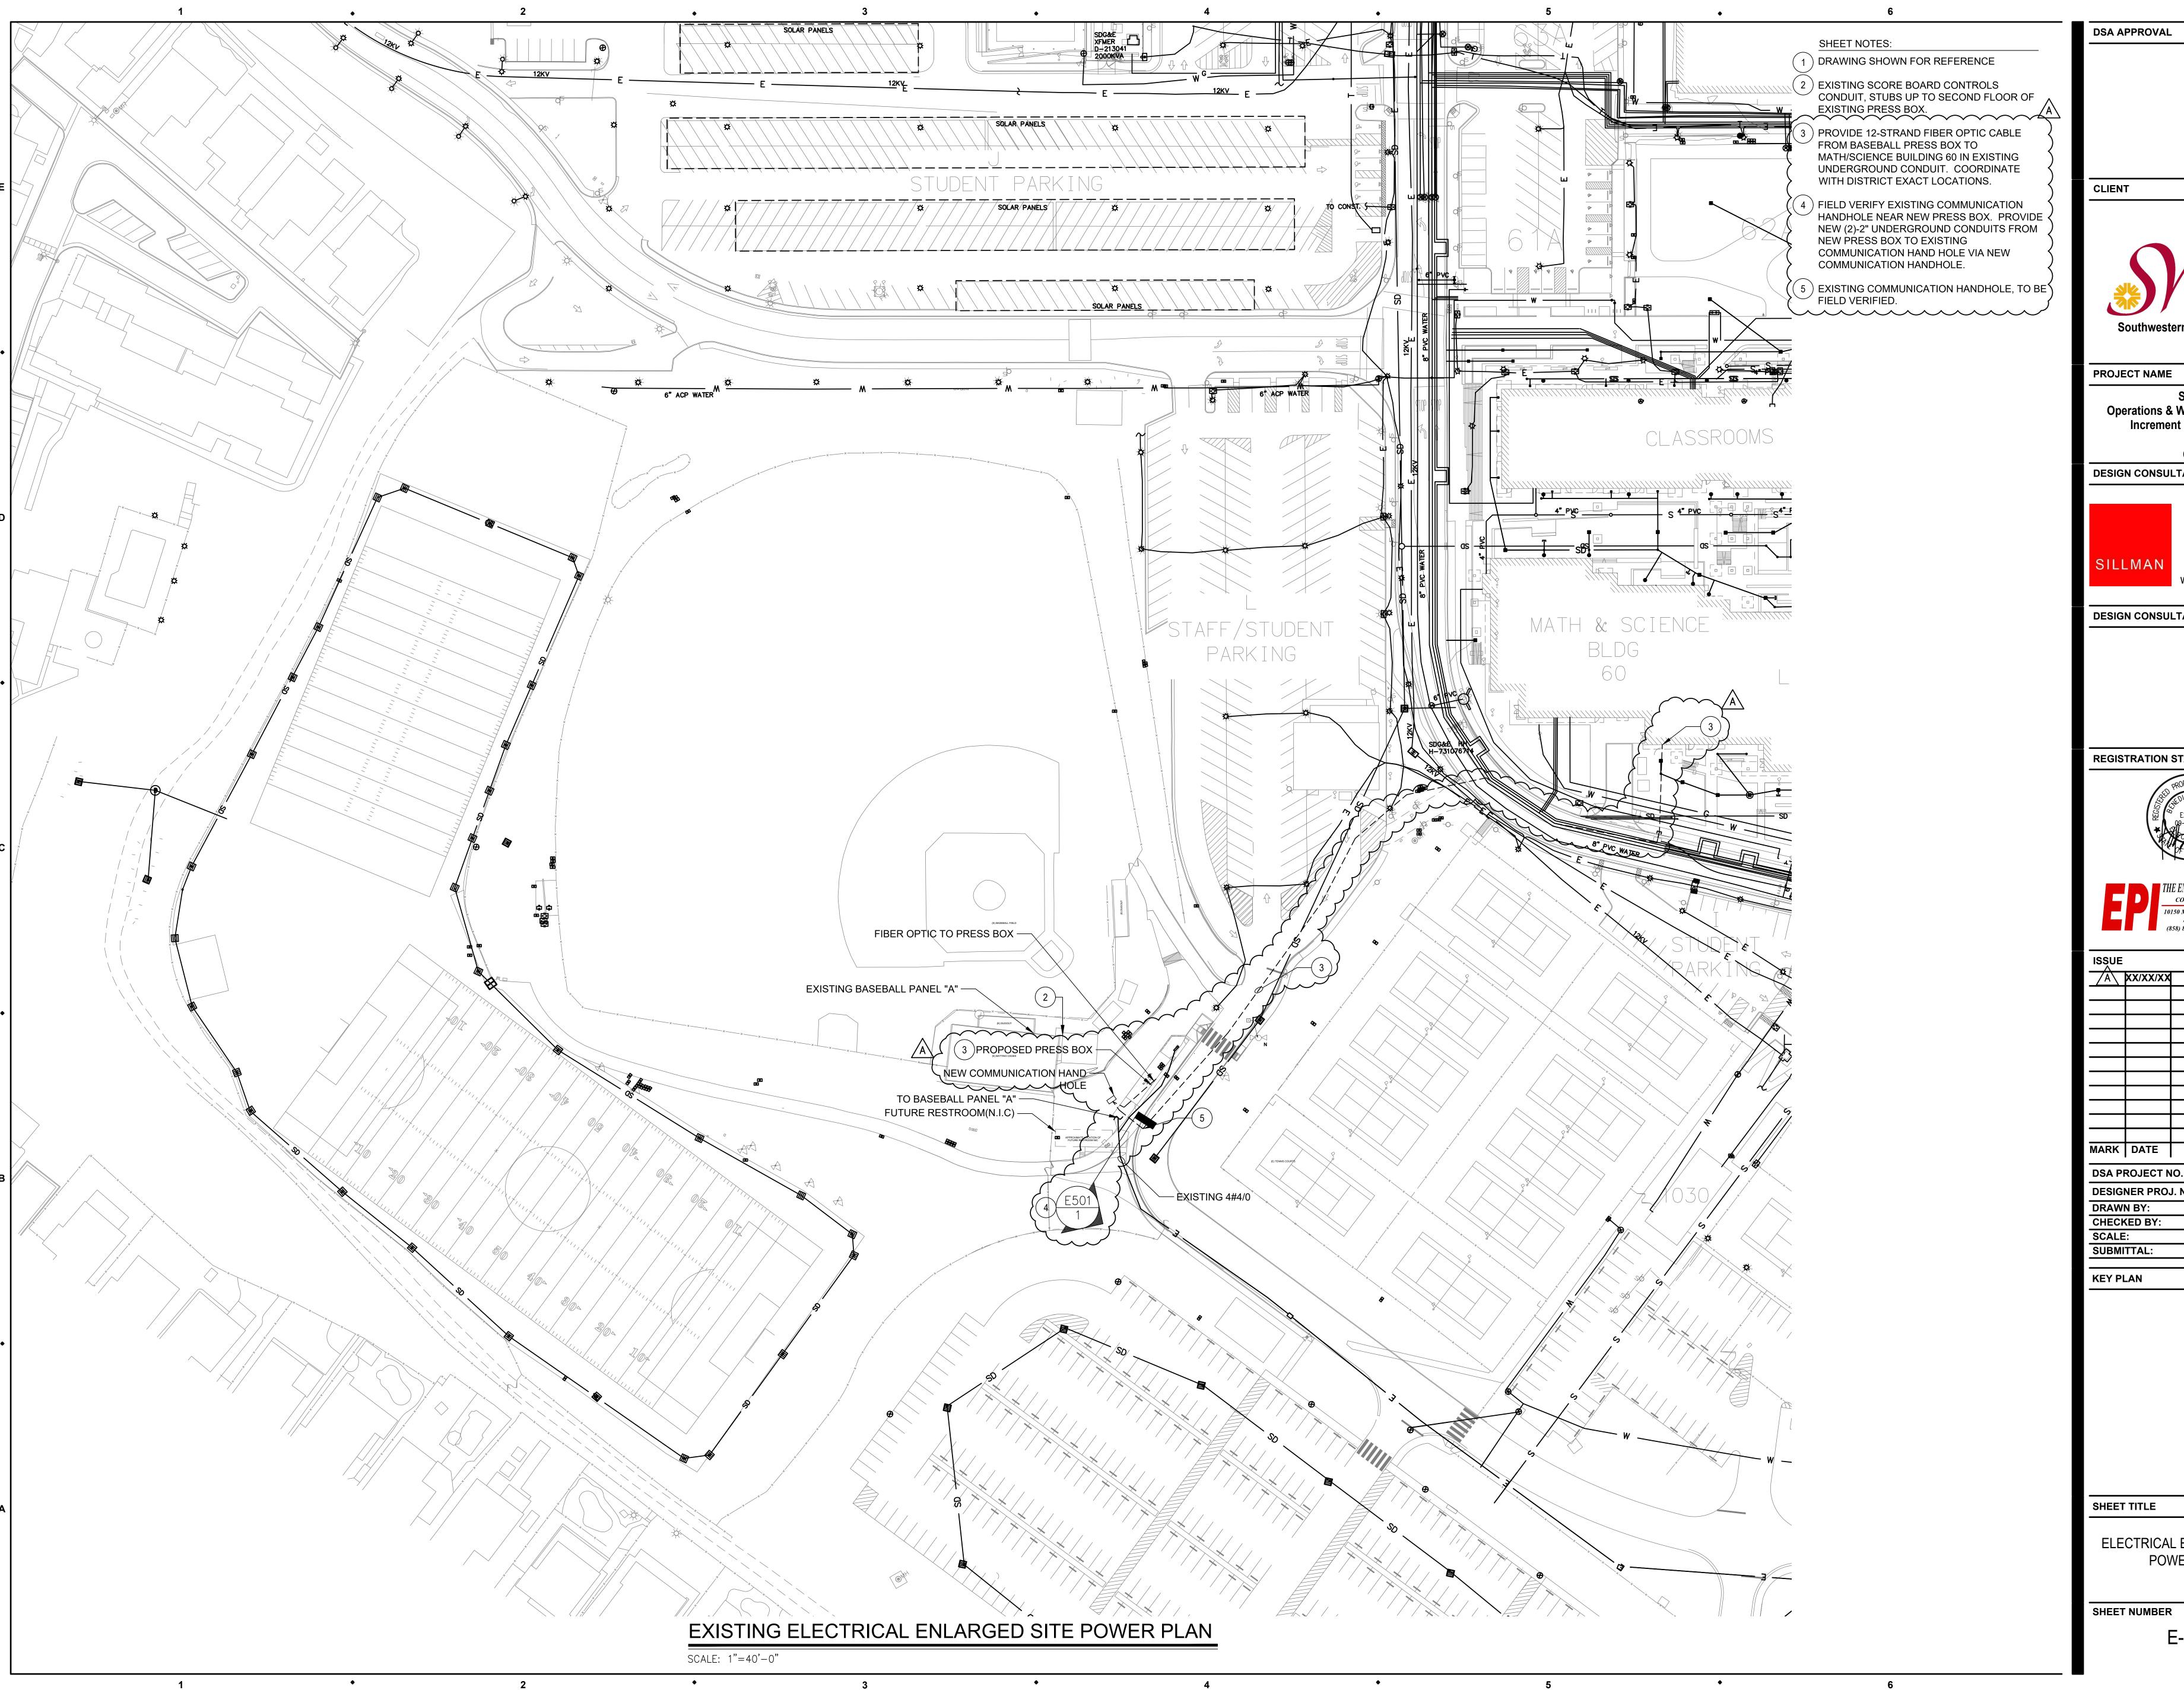

900 Otay Lakes Road Chula Vista, CA 91910

Southwestern College **Operations & Warehouse Relocation** Increment 3 (Building A, B, & C) 900 Otay Lakes Road

**DESIGN CONSULTANT** 



7515 Metropolitan Dr. San Diego, CA 92108 T 619.294.7515 F 619.294.7592 www.sillmanwright.com

Chula Vista, CA 91910

**DESIGN CONSULTANT** 

REGISTRATION STAMPS



DELTA A

10150 MEANLEY DRIVE, SUITE 200 SAN DIEGO, CA 92131 (858) 824-1761 FAX (858) 824-1768

IARK	DATE	DESC	CRIPTION
<b>DSA PROJECT NO.</b> 04-118597			04-118597
DESIGNER PRO L NO			100/0

DESIGNER PROJ. NO. **DRAWN BY: CHECKED BY:** SUBMITTAL:


**KEY PLAN** 

SHEET TITLE

ELECTRICAL ENLARGED SITE POWER PLAN

SHEET NUMBER

E-301

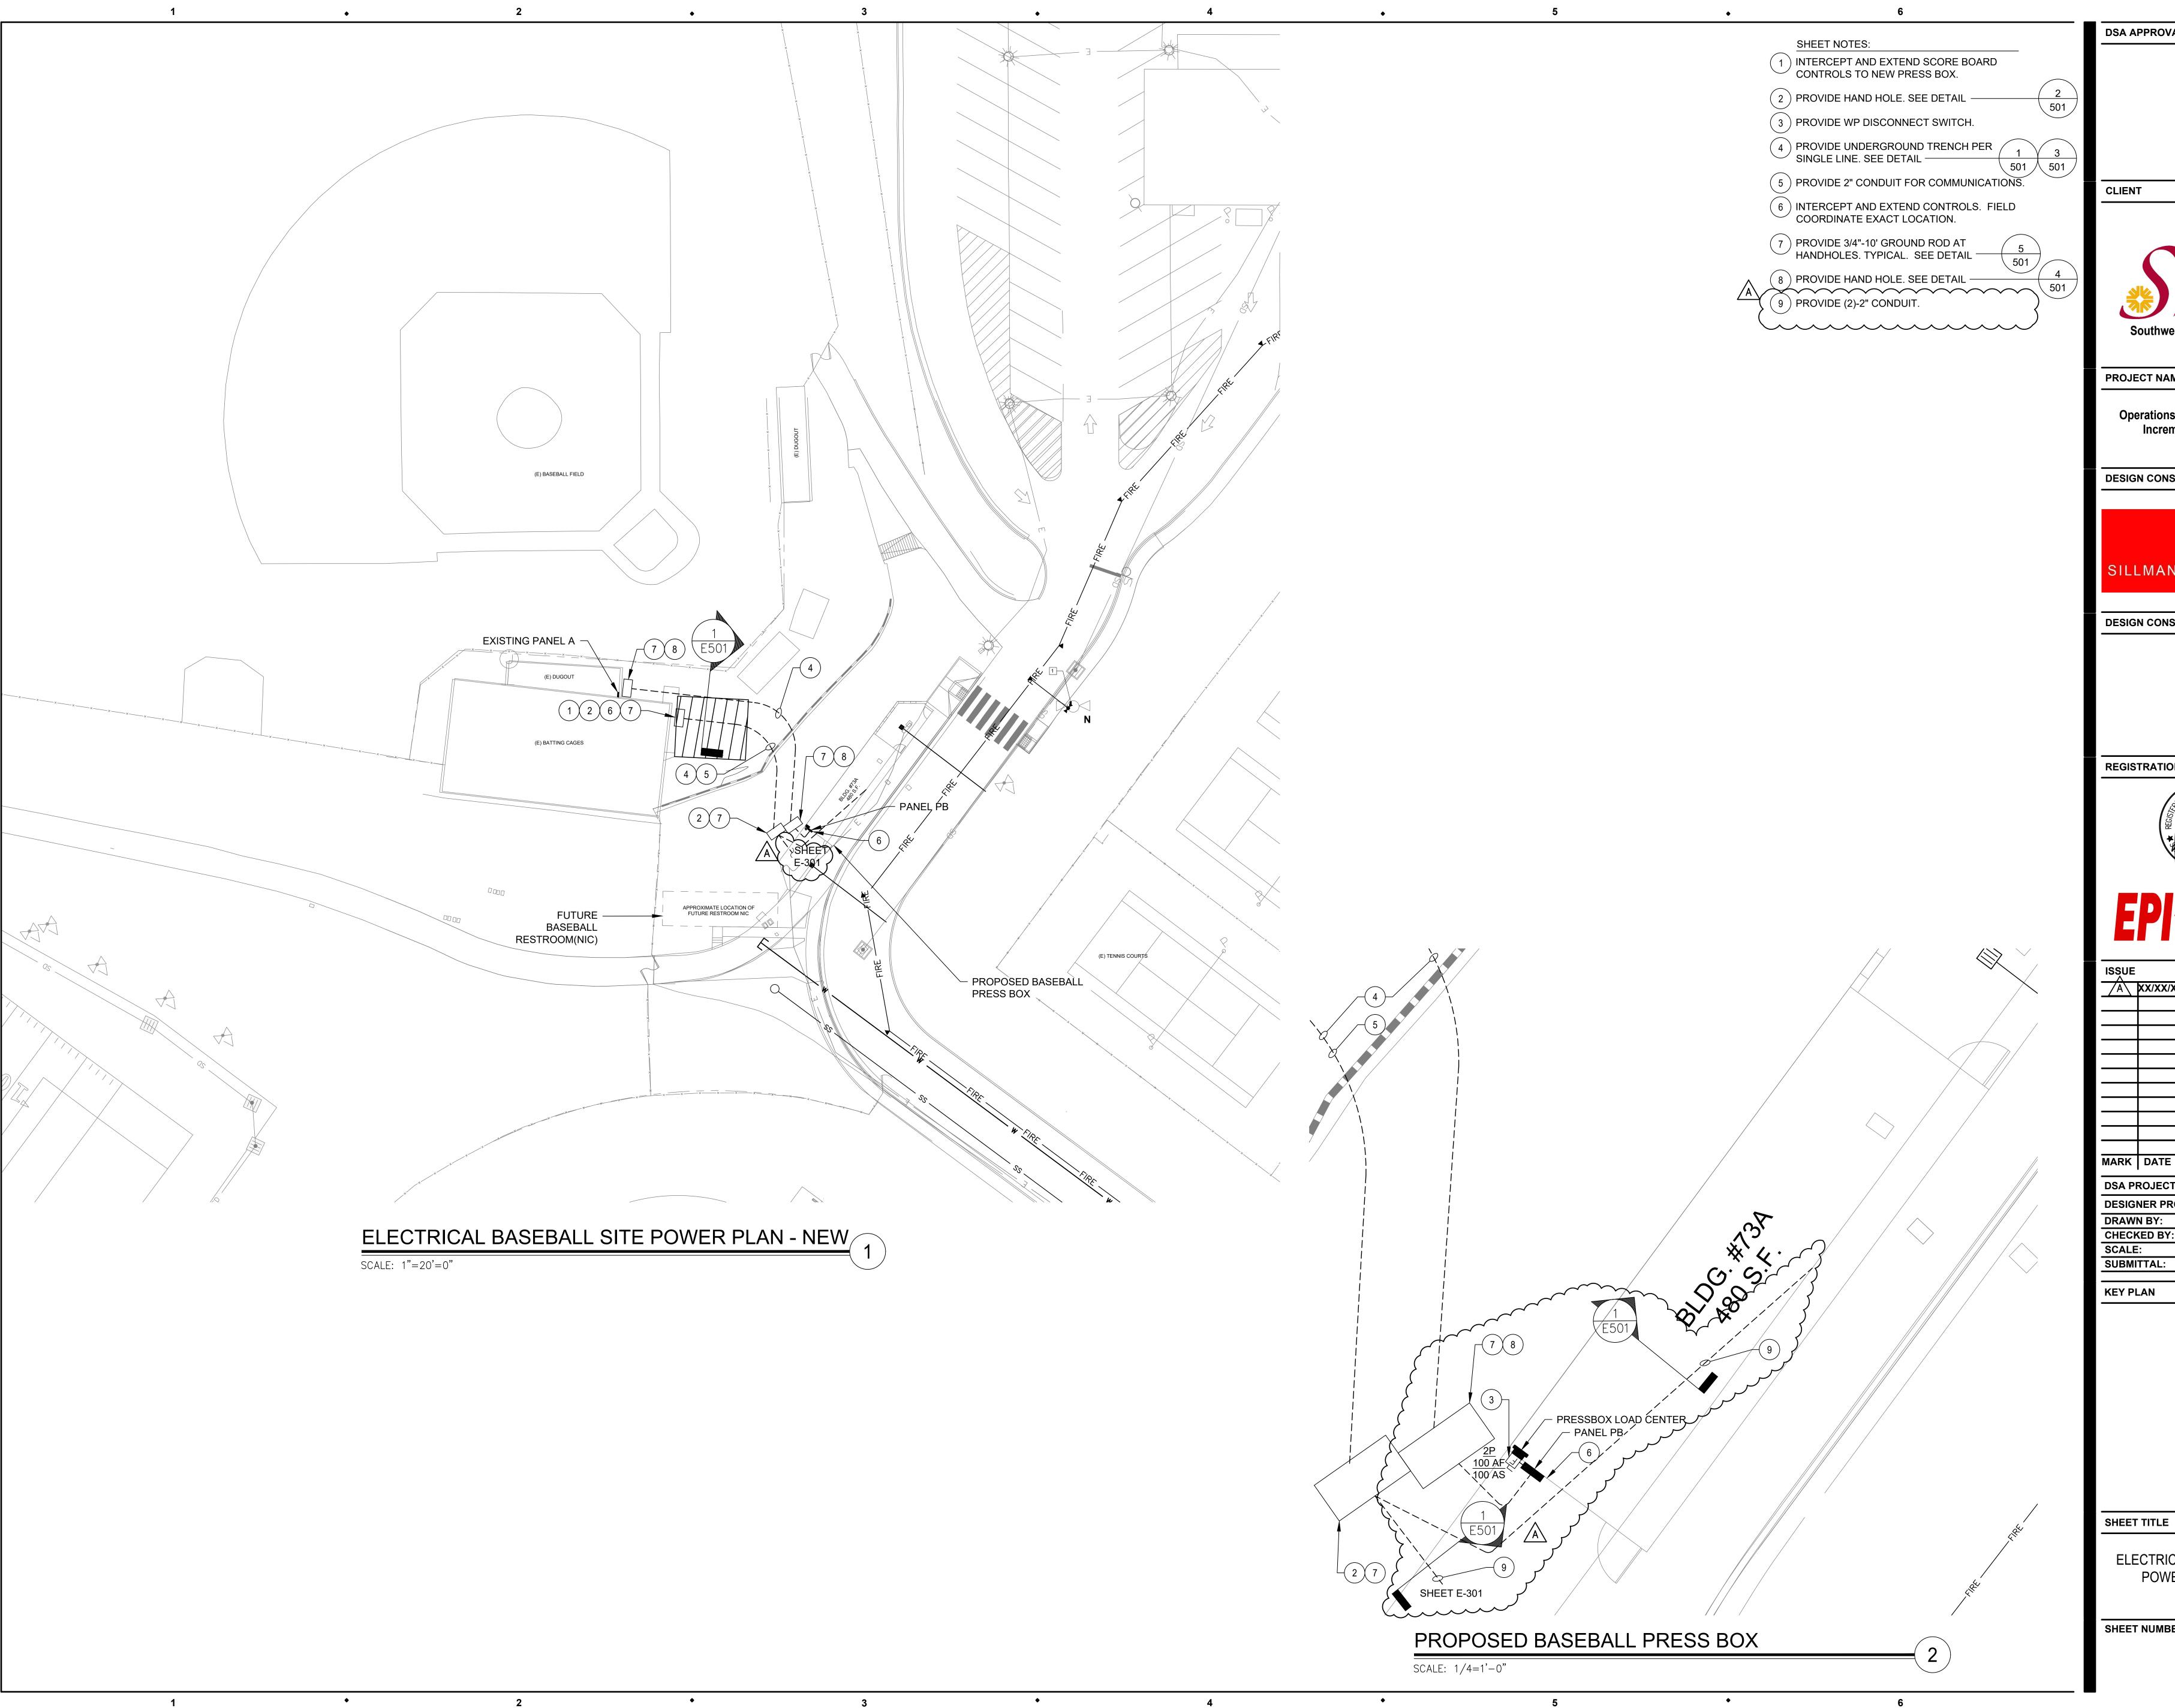

900 Otay Lakes Road Chula Vista, CA 91910

PROJECT NAME

Southwestern College Operations & Warehouse Relocation Increment 3 (Building A, B, & C) 900 Otay Lakes Road

**DESIGN CONSULTANT** 




7515 Metropolitan Dr. Suite 400 San Diego, CA 92108 T 619.294.7515 F 619.294.7592 www.sillmanwright.com

Chula Vista, CA 91910

**DESIGN CONSULTANT** 

REGISTRATION STAMPS

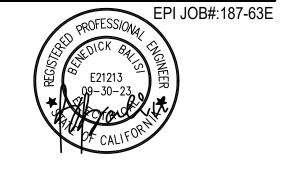

10150 MEANLEY DRIVE, SUITE 200 SAN DIEGO, CA 92131 (858) 824-1761 FAX (858) 824-1768

SSUE				
A	XX/XX/XX	DELTA A		

MARK DATE DESCRIPTION 04-118597 DSA PROJECT NO. **DESIGNER PROJ. NO.** SWA SWA

SUBMITTAL:

**KEY PLAN** 



SHEET TITLE

ELECTRICAL BASEBALL SITE POWER PLAN - NEW

SHEET NUMBER

E-402

SHEET NOTES: 1 PROVIDE WALL MOUNTED CABINET. CABINET SHALL BE A MINIMUM OF 4 UNITS. COORDINATE WITH OWNER EXACT LOCATIONS. (2) PROVIDE PATCH PANEL INSIDE CABINET. (3) DISTRICT TO PROVIDE SWITCH, CONTRACTOR TO INSTALL SWITCH INSIDE CABINET.
CONTRACTOR TO PROVIDE ALL WIRING. CLIENT 4 DISTRICT TO PROVIDE WAPS. COORDINATE LOCATIONS WITH THE DISTRICT. 5 DISTRICT TO PROVIDE EXTERIOR WAPS.
COORDINATE LOCATIONS WITH THE DISTRICT.
WAPS REQUIRE (1-1/2") CONDUIT BETWEEN
THE EXTERIOR OF THE BUILDING AND
ANTENNA. 6 PROVIDE (2)-2" CONDUIT. PROJECT NAME TO HAND HOLE SHEET E-301 ISSUE XX/XX/XX PROPOSED BASEBALL PRESS BOX TELECOM SCALE: 1/4=1'-0" DRAWN BY: SCALE: SUBMITTAL: **KEY PLAN** SHEET TITLE

DSA APPROVAL

Southwestern Community College 900 Otay Lakes Road Chula Vista, CA 91910

Southwestern College Operations & Warehouse Relocation Increment 3 (Building A, B, & C) 900 Otay Lakes Road Chula Vista, CA 91910

**DESIGN CONSULTANT** 



7515 Metropolitan Dr. Suite 400 San Diego, CA 92108 T 619.294.7515 F 619.294.7592 www.sillmanwright.com

**DESIGN CONSULTANT** 

REGISTRATION STAMPS



DELTA A

10150 MEANLEY DRIVE, SUITE 200 SAN DIEGO, CA 92131 (858) 824-1761 FAX (858) 824-1768

MARK	DATE	DESCRIPT	ION
<b>DSA PROJECT NO.</b> 04-118597			4-118597
DESIGNER PROJ. NO. 18048			18048
014/4			<u> </u>

SWA SWA **CHECKED BY:** 

PRESSBOX TELECOM